

SCHEDULE OF OPENINGS			PACKAGE INFORMATION
TAG	SIZE & RATING	SERVICE / DESCRIPTION	DIMENSIONS & WEIGHTS
A3	26"-PIPE	SILENCER OUTLET	TOTAL PACKAGED UNIT
A2	20"-TUBE	ENGINE AIR INLET	PACKAGE HEIGHT: 40'-7 5/16"
A1	20"-TUBE	ENGINE AIR INLET	PACKAGE LENGTH: 100'-8 7/8"
F21	2"-NPT	LIQUID HOLDING TANK PUMPOUT	PACKAGE WIDTH: 39'-8"
F20	2"-NPT	WASTE OIL TANK PUMPOUT	PACKAGE WEIGHT: 493,000 LBS
F4	2"-150#RF	LUBE OIL FILL	CENTER SECTION
U30	2"-150#RF	LOW PRESSURE FLARE	SHIPPING HEIGHT: 16'-4"
U27	2"-150#RF	INSTRUMENT AIR SUPPLY	SHIPPING LENGTH: 50'-2 3/8"
U25	3"-150#RF	START GAS SUPPLY	SHIPPING WIDTH: 19'-7 11/16"
U23	2"-150#RF	PACKING PURGE SUPPLY	SHIPPING WEIGHT: 240,600 LBS
U21	2"-150#RF	FUEL GAS SUPPLY	CENTER SECTION
U20	12"-150#RF	FLARE HEADER	SHIPPING HEIGHT: 12'-9 3/8"
U7	2"-600#RF	SCRUBBER DRAIN HEADER	SHIPPING LENGTH: 44'-11 5/16"
U1	2"-150#RF	STG. 1 SCRUBBER DRAIN	SHIPPING WIDTH: 4'-4"
P9	6"-600#RF	PACKAGE OUTLET	SHIPPING WEIGHT: 24,000 LBS
P1	12"-300#RF	PACKAGE INLET	NORTH WING
			SHIPPING HEIGHT: 13'-1 5/8"
			SHIPPING LENGTH: 44'-11 5/16"
			SHIPPING WIDTH: 3'-10 1/2"
			SHIPPING WEIGHT: 31,400 LBS
			SOUTH WING
			SHIPPING HEIGHT: 13'-1 5/8"
			SHIPPING LENGTH: 44'-11 5/16"
			SHIPPING WIDTH: 3'-10 1/2"
			SHIPPING WEIGHT: 31,400 LBS
			COOLER
			SHIPPING HEIGHT: 14'-4 5/8"
			SHIPPING LENGTH: 52'-0 3/8"
			SHIPPING WIDTH: 14'-6 1/8"
			SHIPPING WEIGHT: 75,000 LBS
			SILENCER
			SHIPPING HEIGHT: 6'-5 3/16"
			SHIPPING LENGTH: 28'-2 9/16"
			SHIPPING WIDTH: 6'-0 3/8"
			SHIPPING WEIGHT: 7413 LBS

- NOTES**
1. ALL SKID EDGE CONNECTION PROJECTIONS 6" UNLESS OTHERWISE NOTED.
 2. FOR CONCRETE INFORMATION REFER TO 22-1390-000
 3. THE ABOVE MENTIONED WEIGHT IS AN APPROXIMATE VALUE BASED ON INFORMATION FROM OUR VENDORS AND OUR INTERNAL ESTIMATING PROGRAM. IT IS THE RESPONSIBILITY OF THE CARRIER TO CONFIRM THE ACTUAL WEIGHT OF THE PACKAGE PRIOR TO TRANSPORTING THE UNIT.
 4. UTILITY CONNECTIONS TO BE 6" CLEAR OF ANY JACKING OR LIFTING POINTS TO AVOID CONFLICT WHEN SHIPPING.

ISSUED FOR CONSTRUCTION


IFC

2023/10/05

REV	DATE	CREATED	REVIEWED	APPROVED	DESCRIPTION	PAPER SIZE	SCALE	DWG#	REV
1	23-10-05	SB	CA	TB	RAISED SILENCER FOR ENGINE CONNECTION	11"x17"	NTS	22-1390-100	1
0	23-05-26	SB	CP	TB	ISSUED FOR CONSTRUCTION				
A	23-03-10	CK	CP	TB	ISSUED FOR APPROVAL				

GENERAL ARRANGEMENT (PLAN VIEW)
 CATERPILLAR G3612LE A4 / ARIEL KBZ/4-3 / AIR-X-LIMITED 156-22F

SHEET#: 1 OF 7
 JOB#: 22-1390

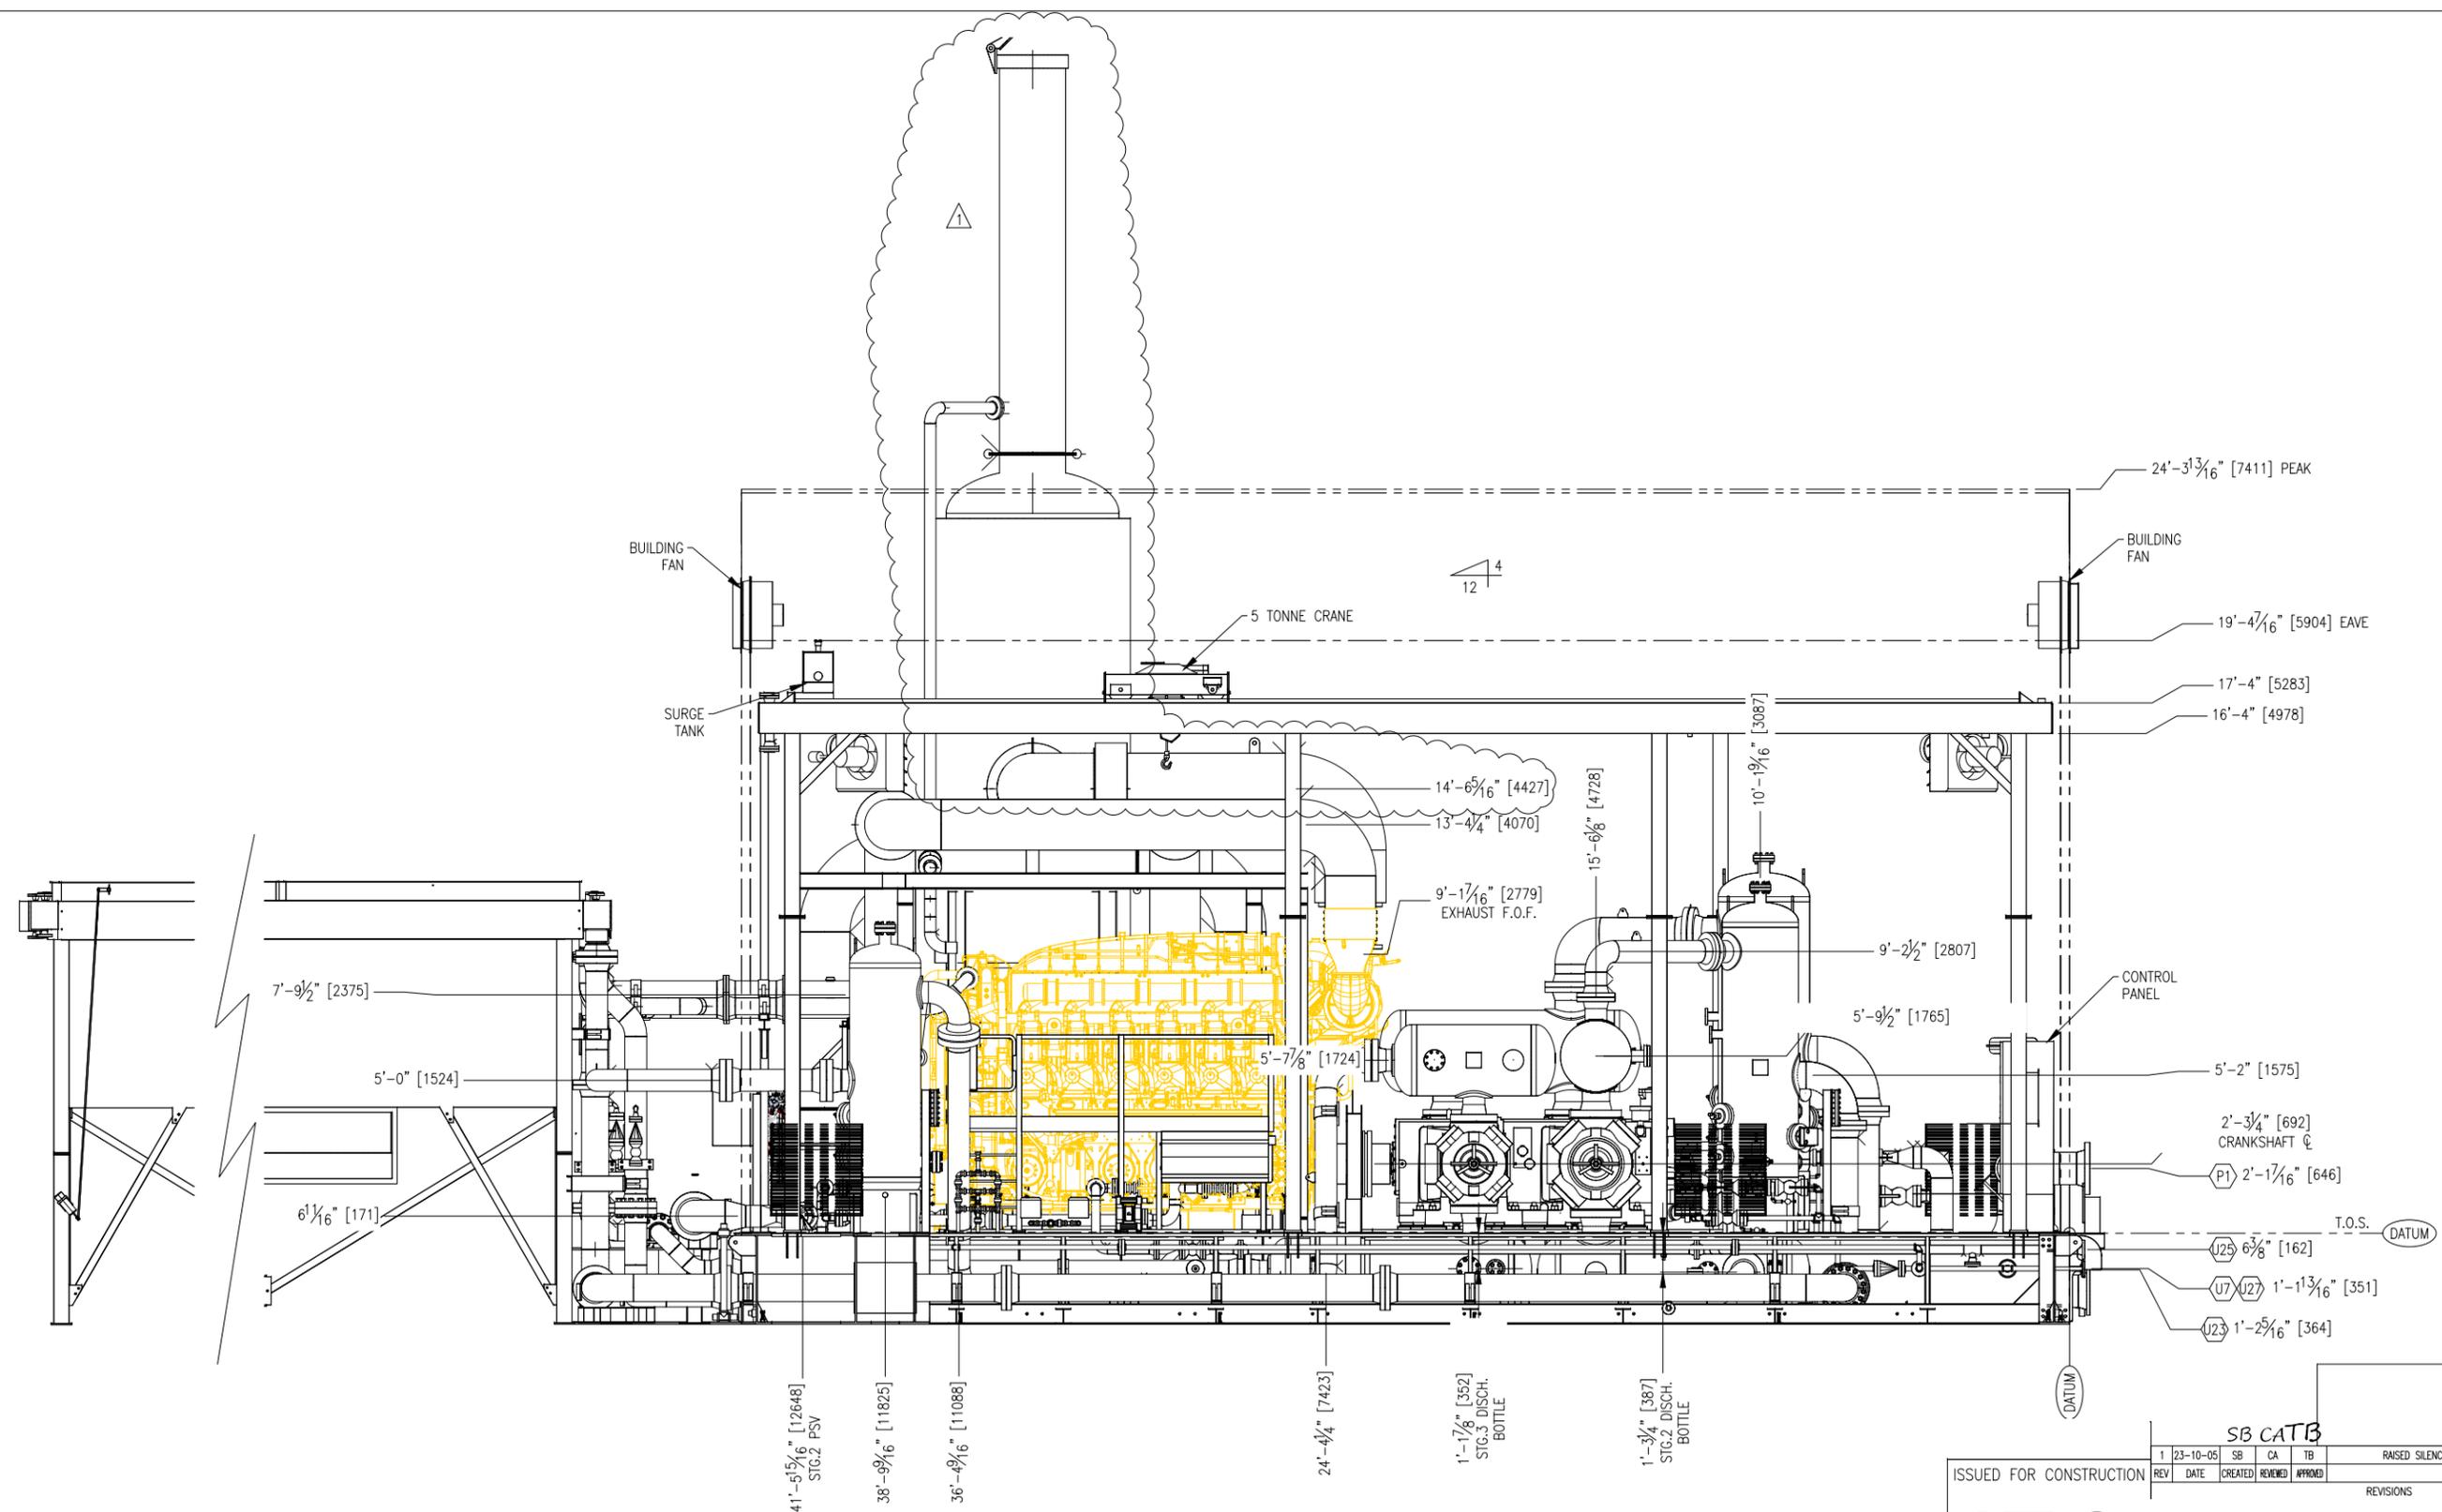

ISSUED FOR CONSTRUCTION

IFC

2023/10/05

SB CAT13




REV	DATE	CREATED	REVIEWED	APPROVED	DESCRIPTION
1	23-10-05	SB	CA	TB	RAISED SILENCER FOR ENGINE CONNECTION

REVISIONS

GENERAL ARRANGEMENT (SOUTH ELEVATION VIEW)
CATERPILLAR G3612LE A4 / ARIEL KBZ/4-3 / AIR-X-LIMITED 156-22F

SHEET#: 2 OF 7
JOB#: 22-1390

PAPER SIZE	SCALE	DWG#	REV
11"x17"	NTS	22-1390-100	1

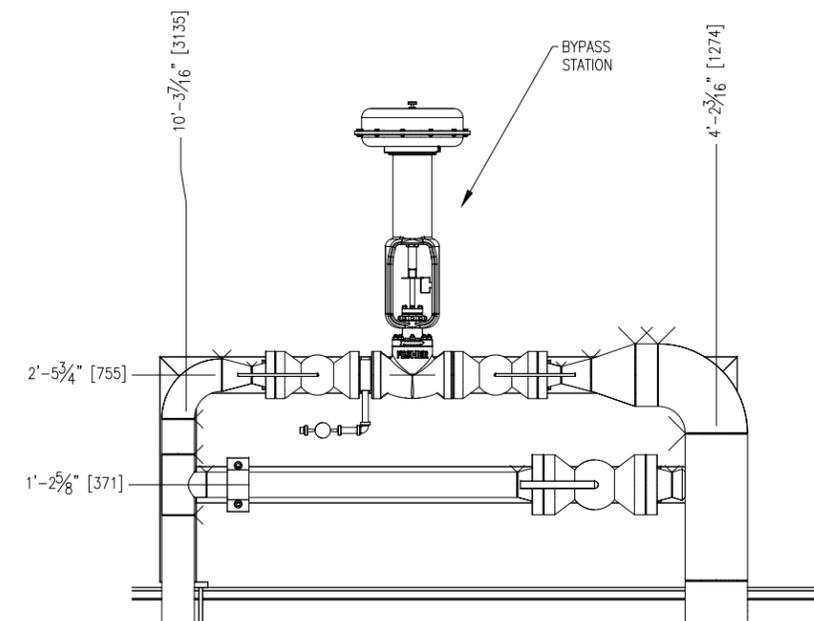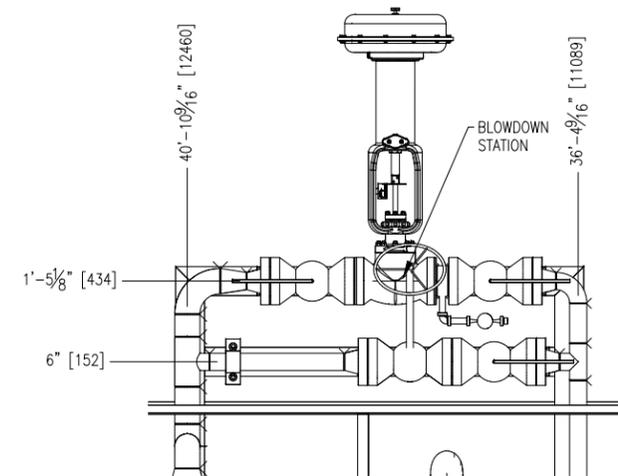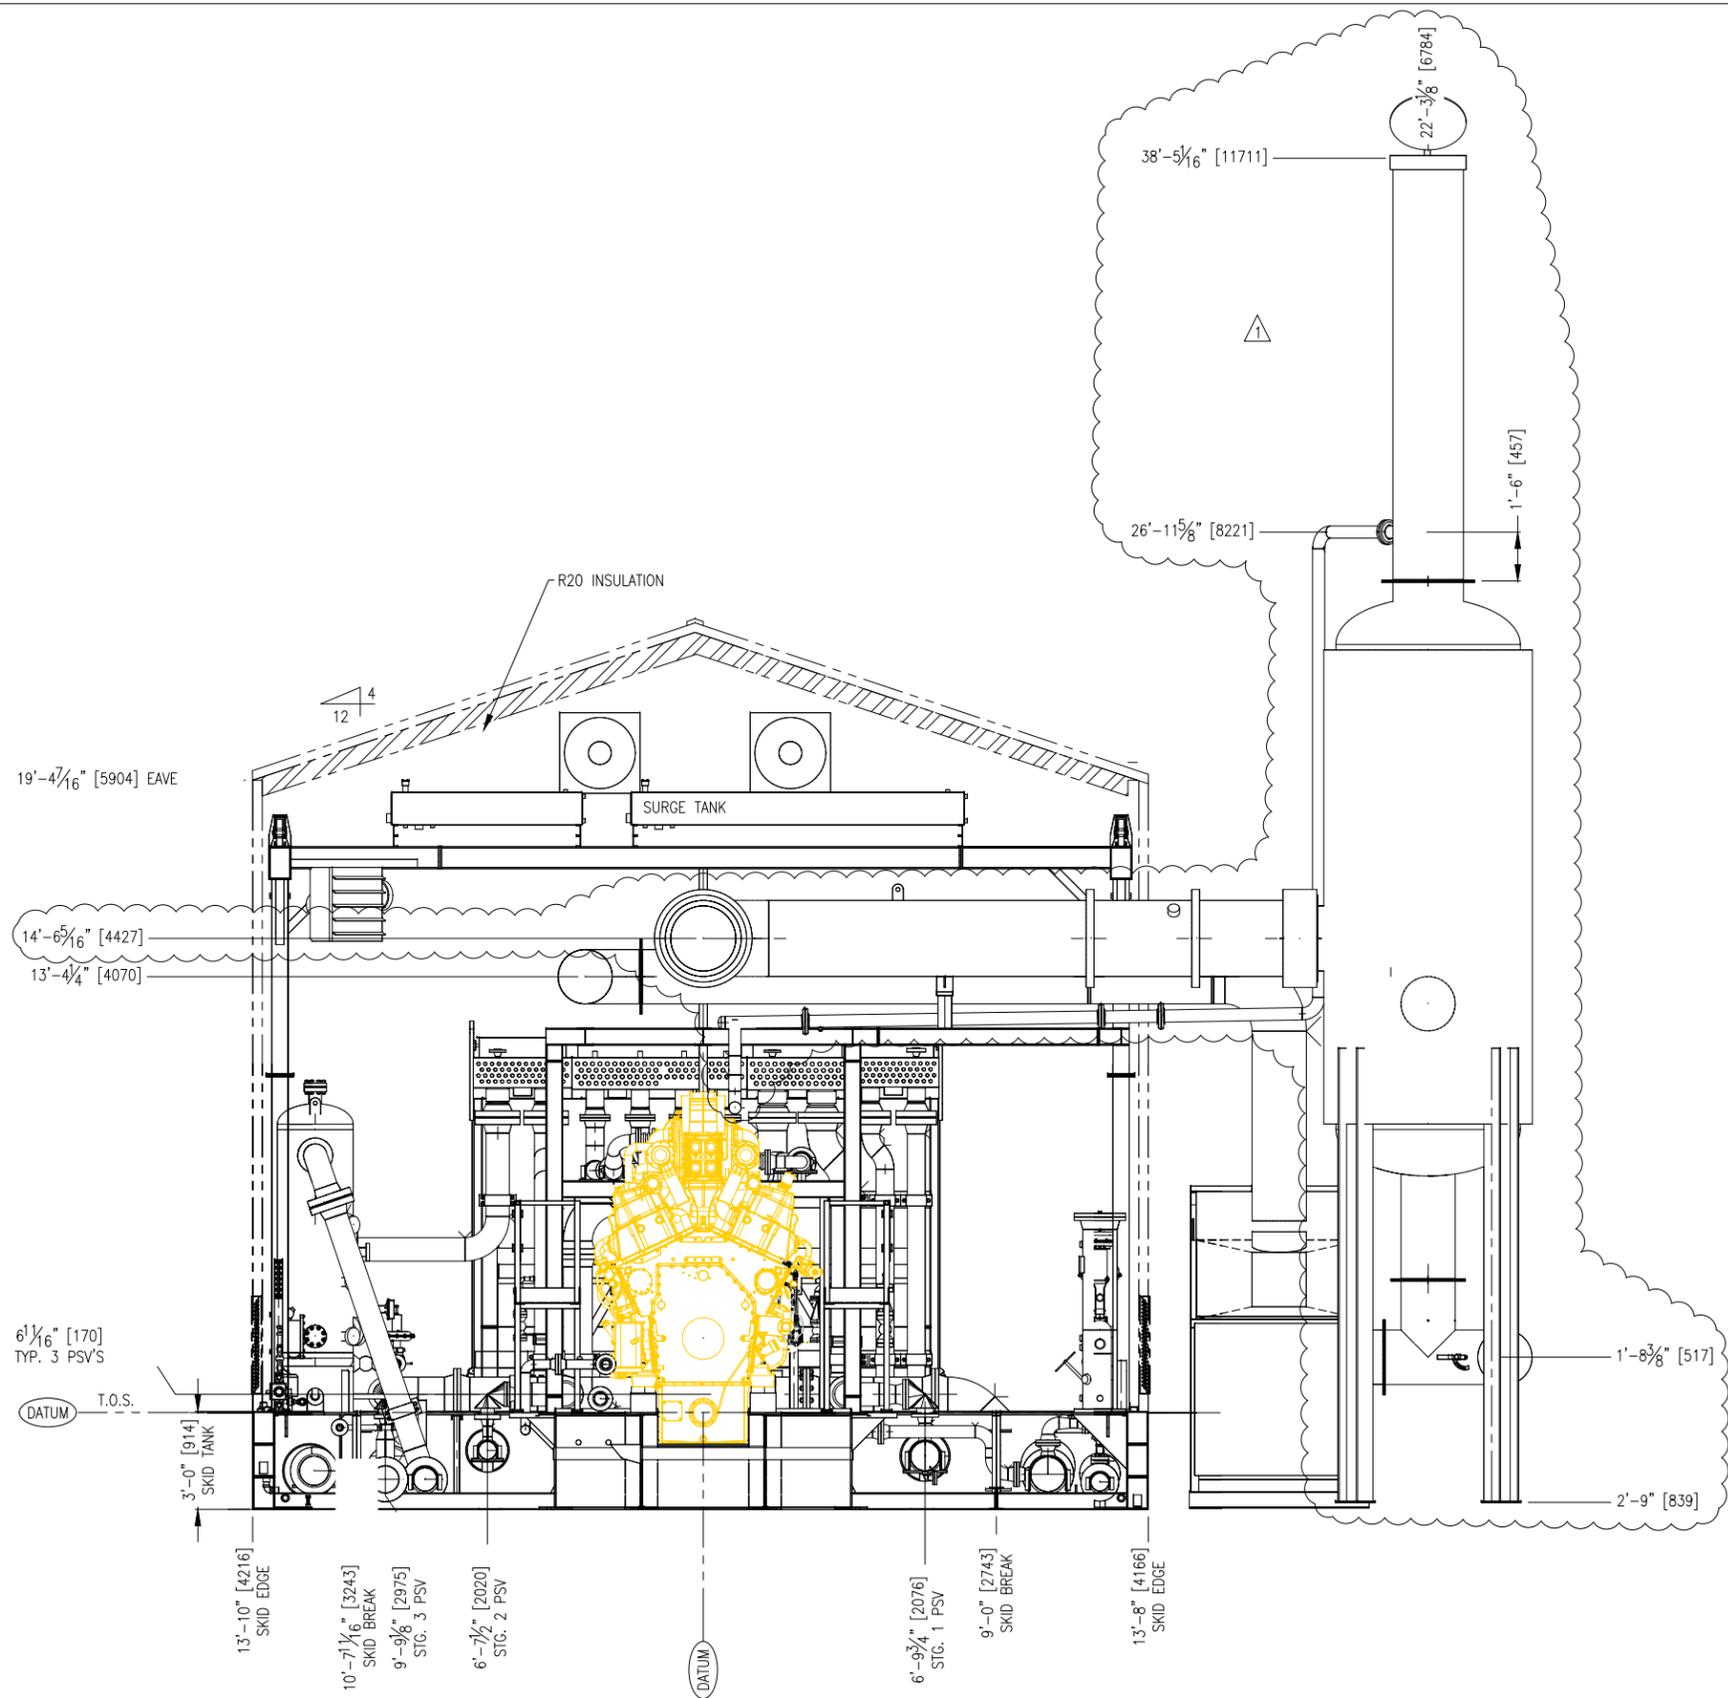

ISSUED FOR CONSTRUCTION

IFC

2023/10/05

SB CAT B				
REV	DATE	CREATED	REVIEWED	APPROVED
1	23-10-05	SB	CA	TB


RAISED SILENCER FOR ENGINE CONNECTION
DESCRIPTION

REVISIONS

GENERAL ARRANGEMENT (COOLER END SECTION VIEW)
CATERPILLAR G3612LE A4 / ARIEL KBZ/4-3 / AIR-X-LIMITED 156-22F

PAPER SIZE 11"x17" SCALE NTS DWG# 22-1390-100 REV 1

SHEET#: 4 OF 7
JOB#: 22-1390

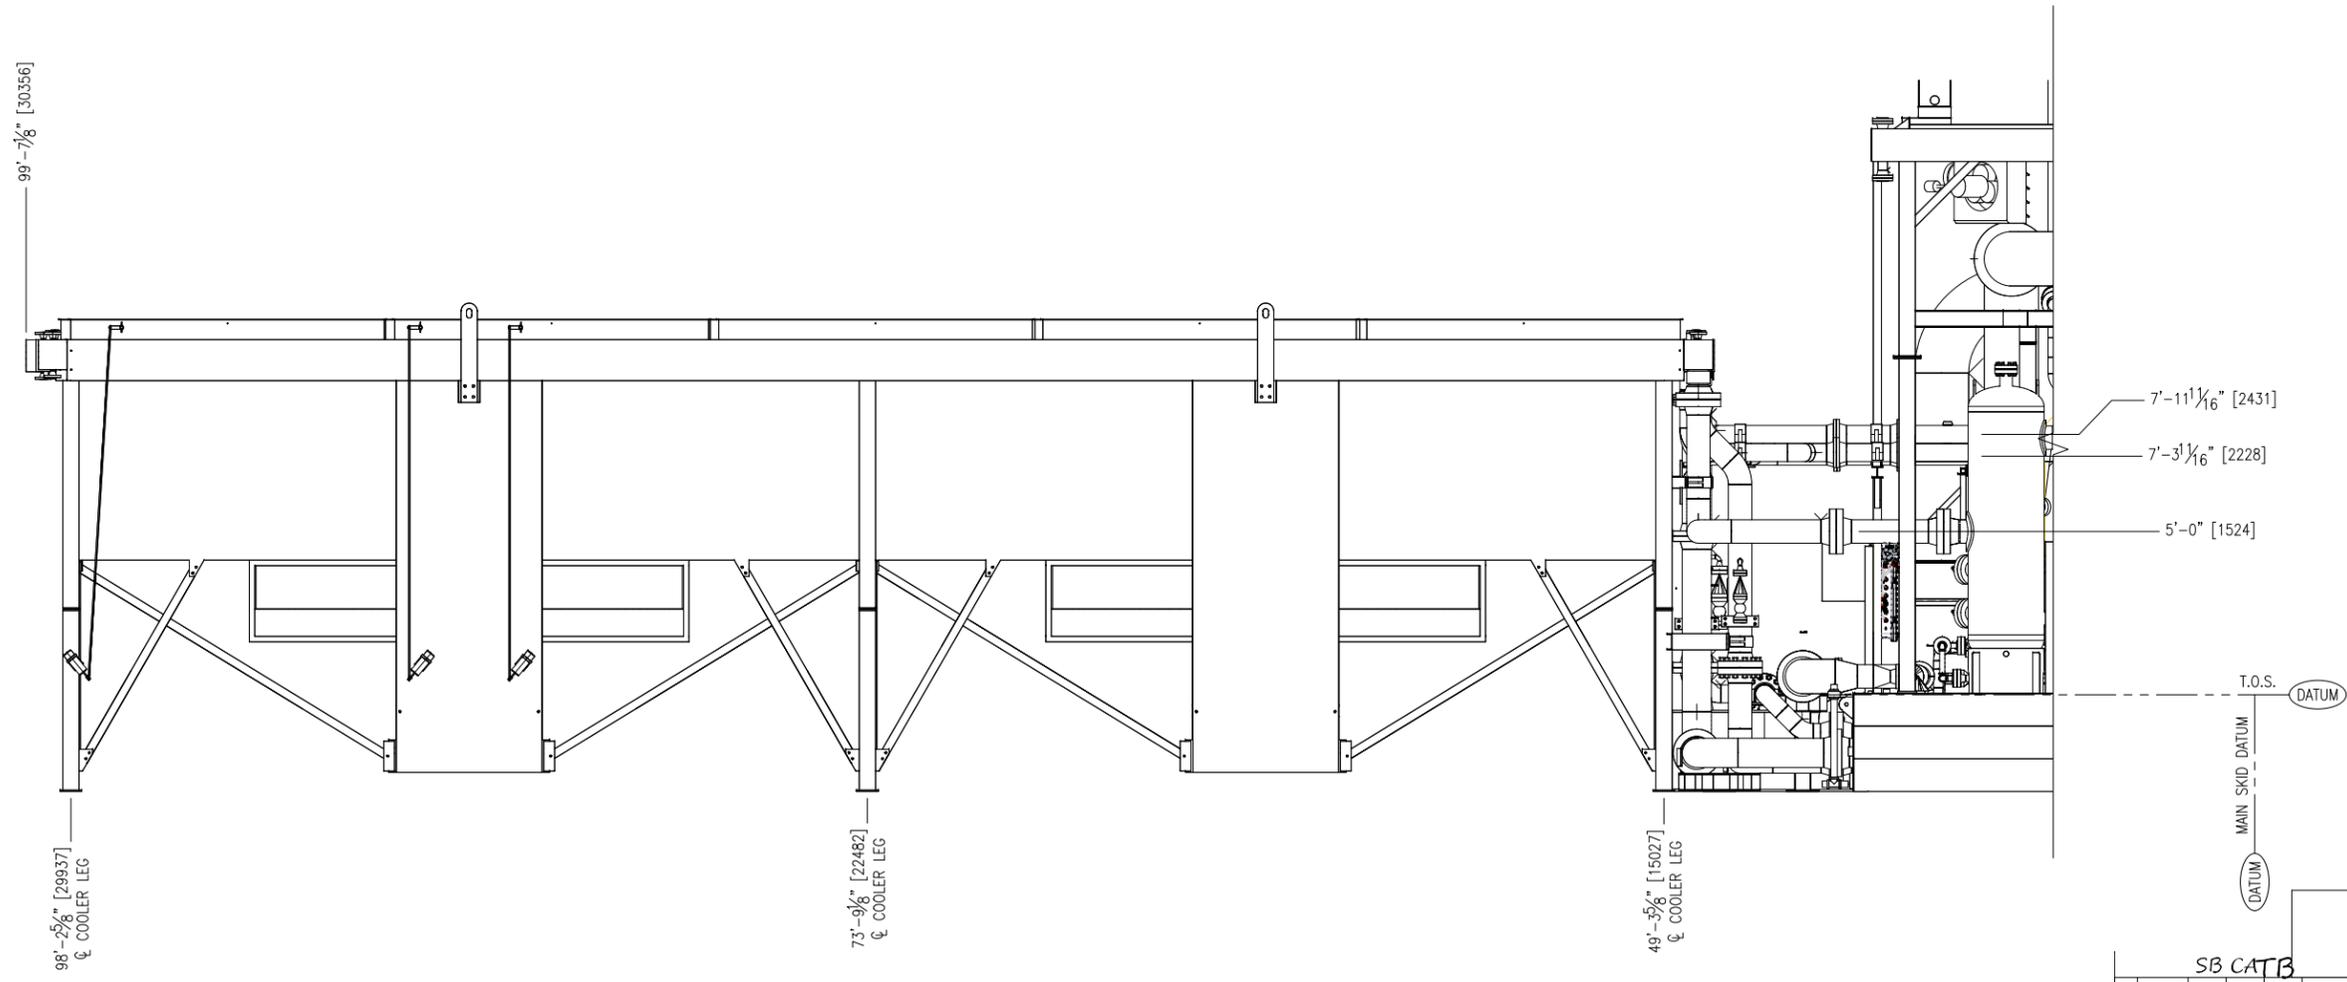


ISSUED FOR CONSTRUCTION		SB CAT B				RAISED SILENCER FOR ENGINE CONNECTION	
REV	DATE	CREATED	REVIEWED	APPROVED	DESCRIPTION	REVISIONS	
1	23-10-05	SB	CA	TB			
GENERAL ARRANGEMENT (COOLER ELEVATION VIEW) CATERPILLAR G3612LE A4 / ARIEL KBZ/4-3 / AIR-X-LIMITED 156-22F							
PAPER SIZE 11"x17"		SCALE NTS		DWG# 22-1390-100		REV 1	

IFC

2023/10/05

SHEET#: 5 OF 7

JOB#: 22-1390

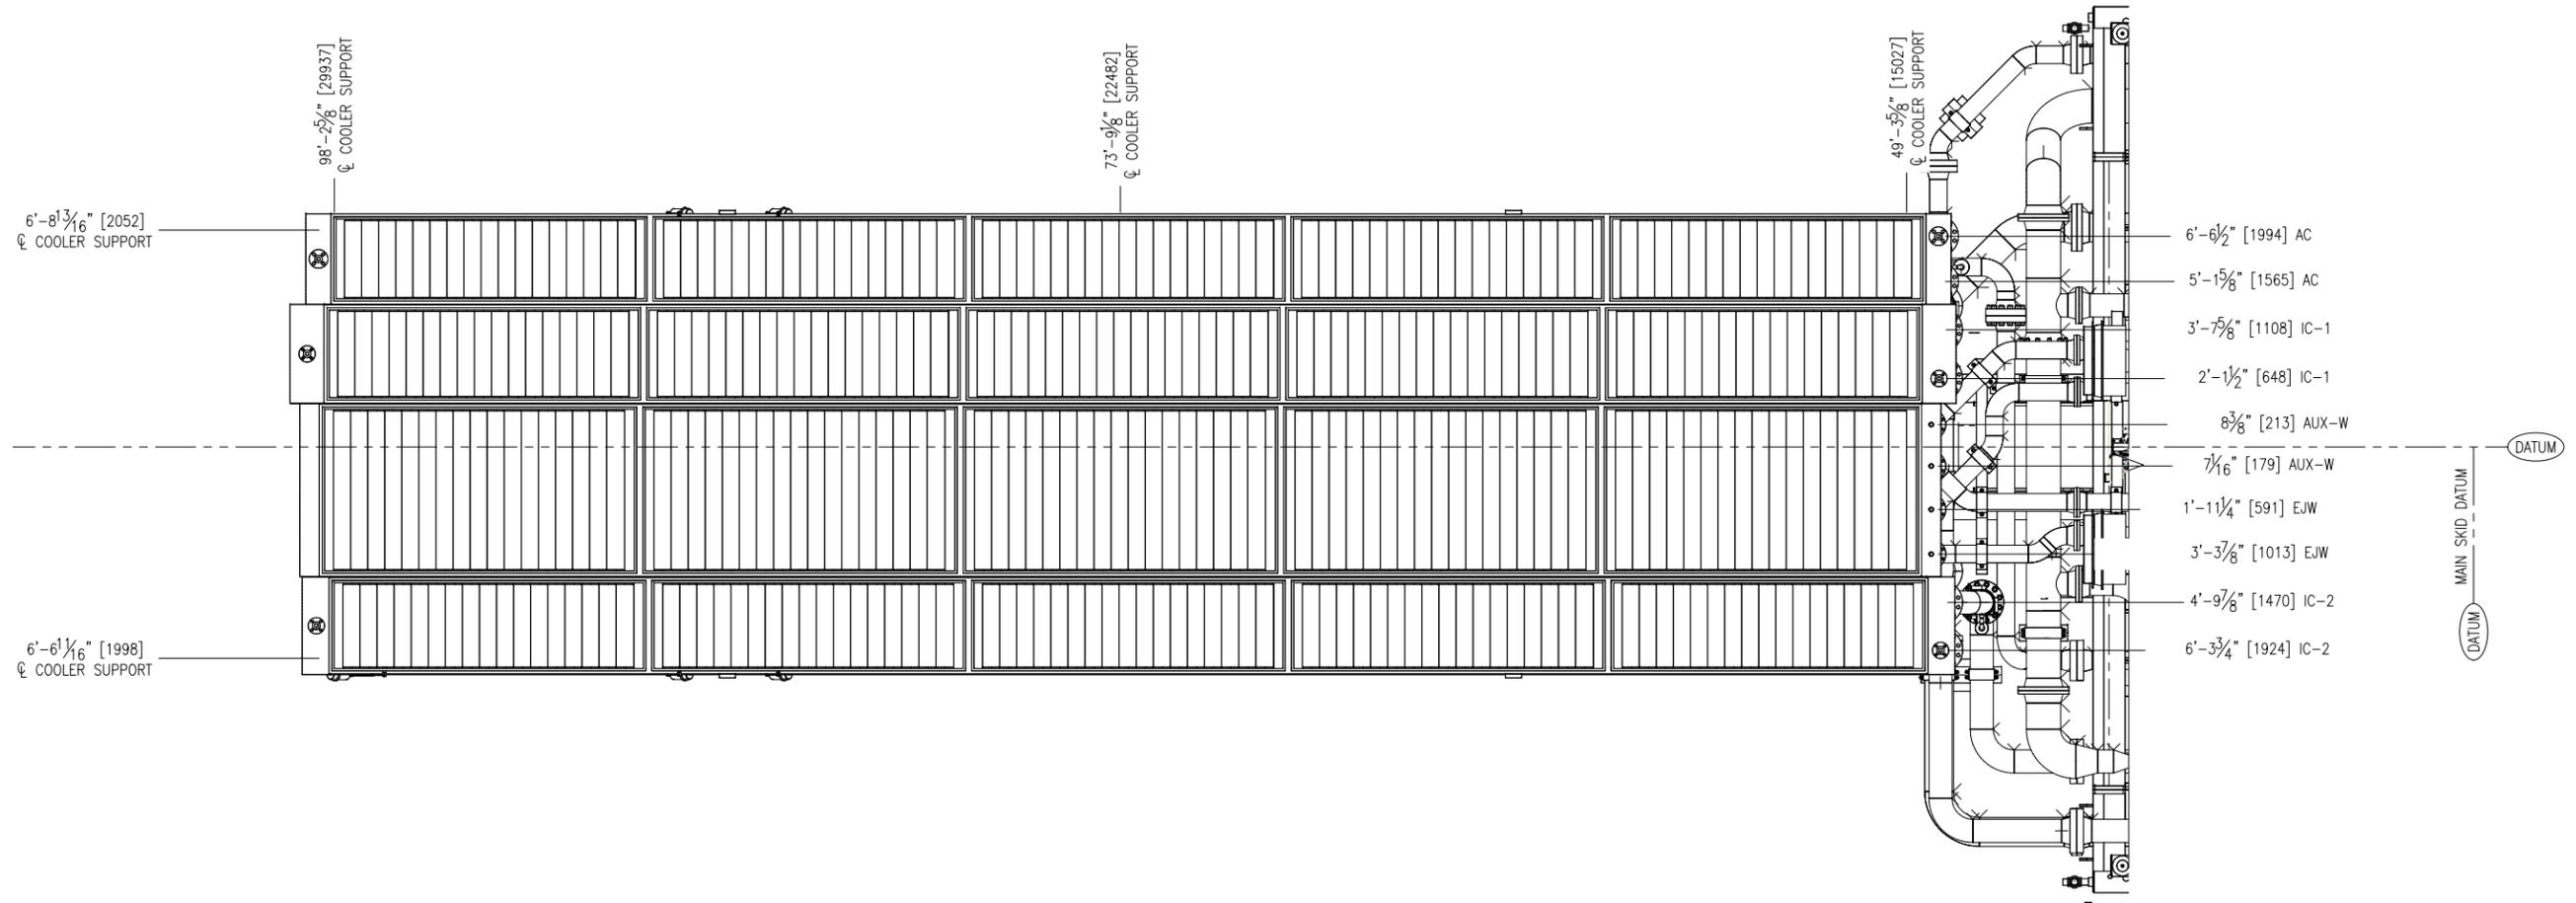


ISSUED FOR CONSTRUCTION

IFC

2023/10/05

SB CA TB				
REV	DATE	CREATED	REVIEWED	APPROVED
1	23-10-05	SB	CA	TB
RAISED SILENCER FOR ENGINE CONNECTION				
DESCRIPTION				
REVISIONS				
GENERAL ARRANGEMENT (COOLER PLAN VIEW)				
CATERPILLAR G3612LE A4 / ARIEL KBZ/4-3 / AIR-X-LIMITED 156-22F				
SHEET#: 6 OF 7				
JOB#: 22-1390				
PAPER SIZE	SCALE	DWG#	REV	
11"x17"	NTS	22-1390-100	1	

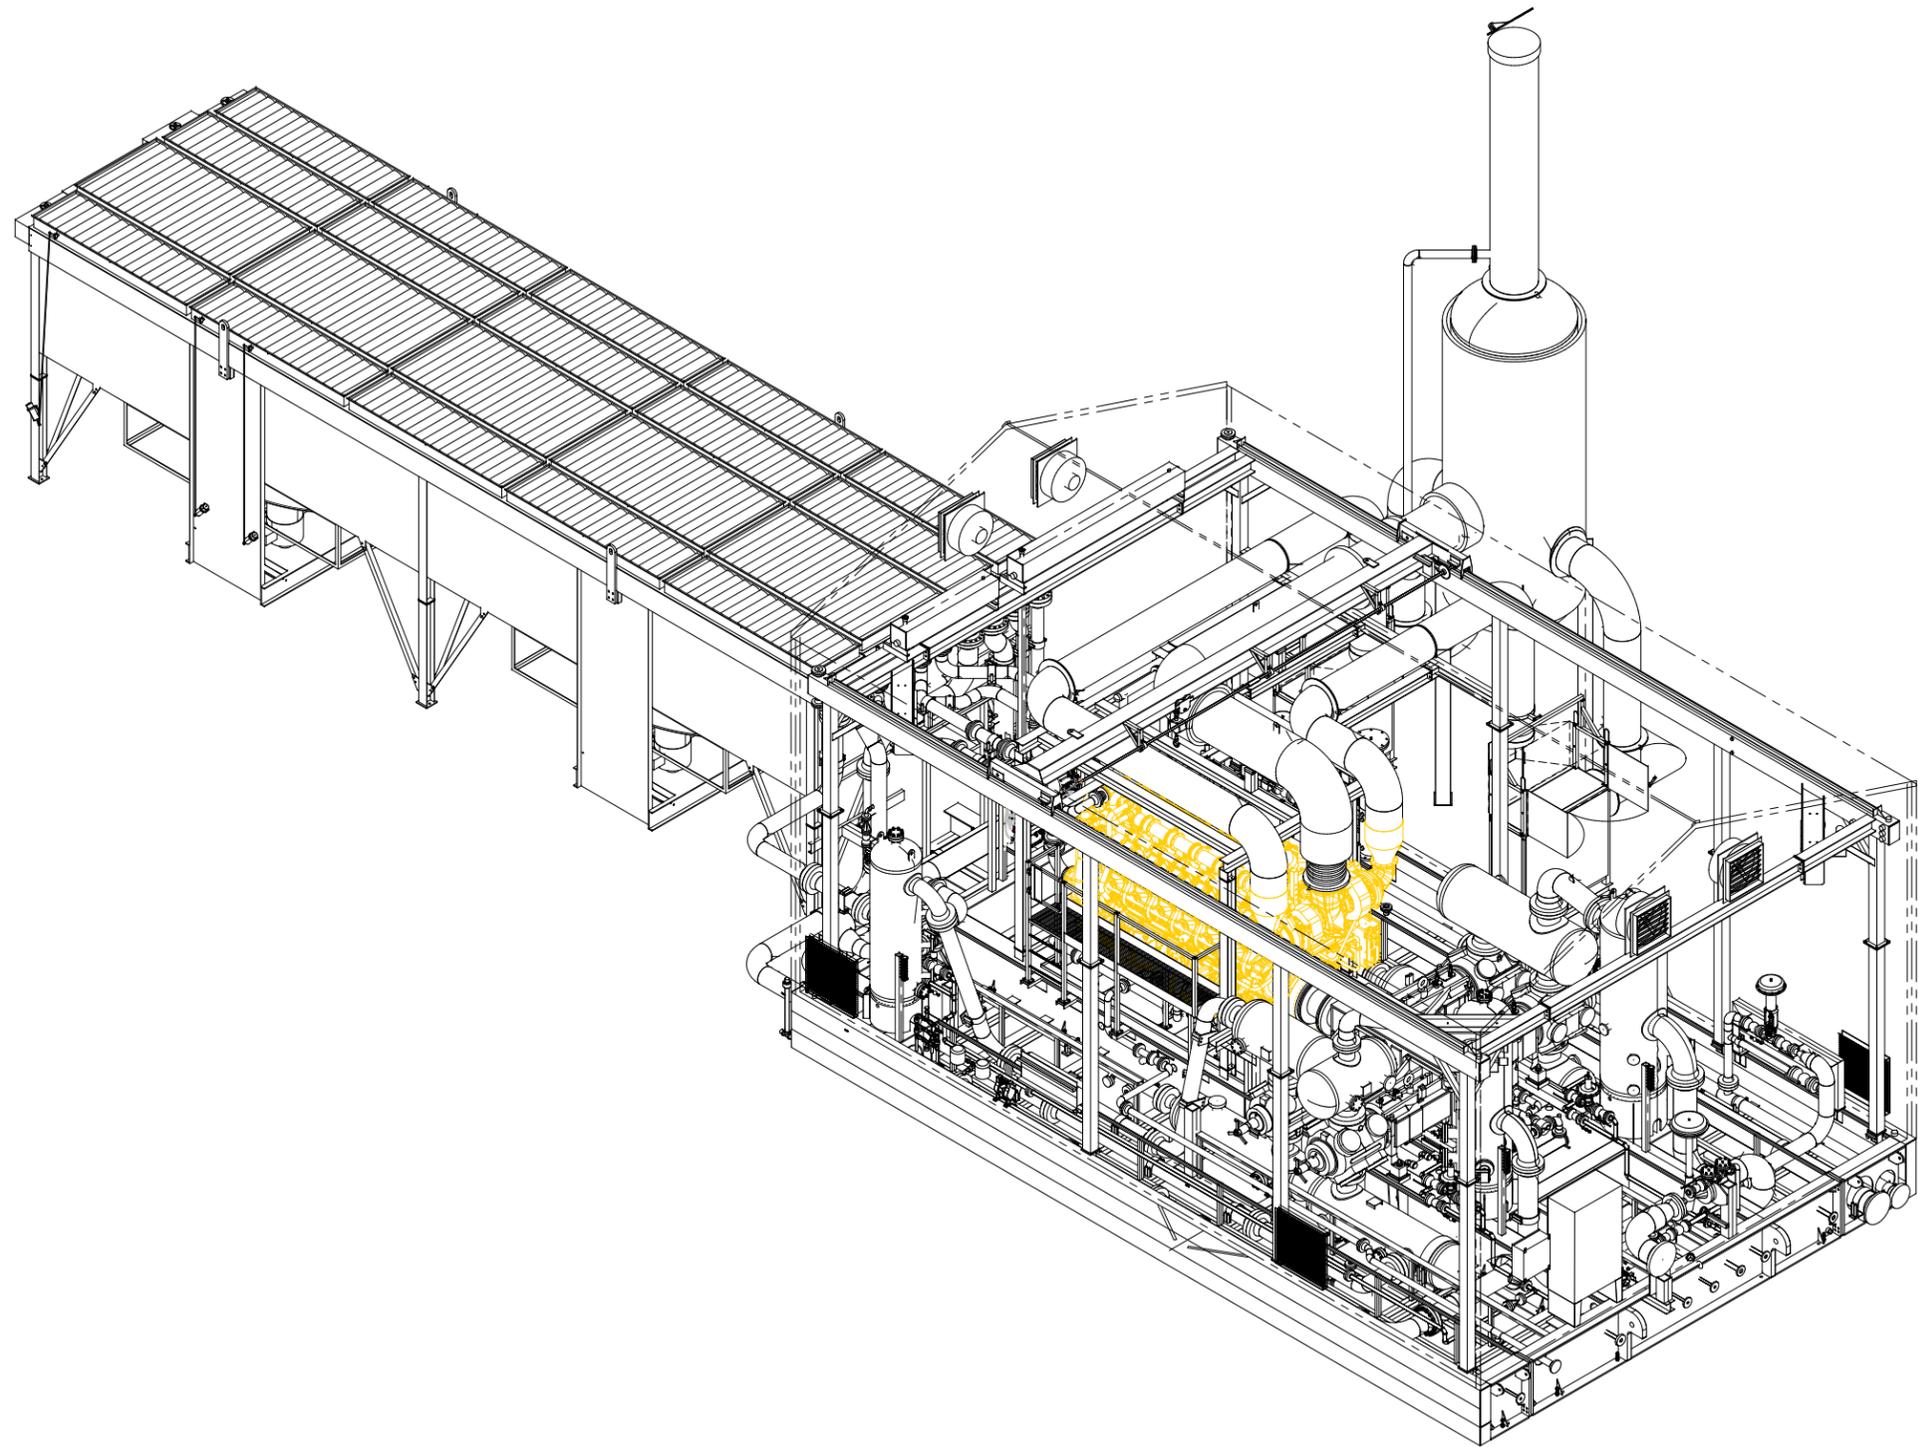

ISSUED FOR CONSTRUCTION

IFC

2023/10/05

SB CAT B

REV	DATE	CREATED	REVIEWED	APPROVED	DESCRIPTION
1	23-10-05	SB	CA	TB	RAISED SILENCER FOR ENGINE CONNECTION

GENERAL ARRANGEMENT (ISO VIEW)
CATERPILLAR G3612LE A4 / ARIEL KBZ/4-3 / AIR-X-LIMITED 156-22F

SHEET#: 7 OF 7

JOB#: 22-1390

PAPER SIZE 11"x17"	SCALE NTS	DWG# 22-1390-100	REV 1
-----------------------	--------------	---------------------	----------