



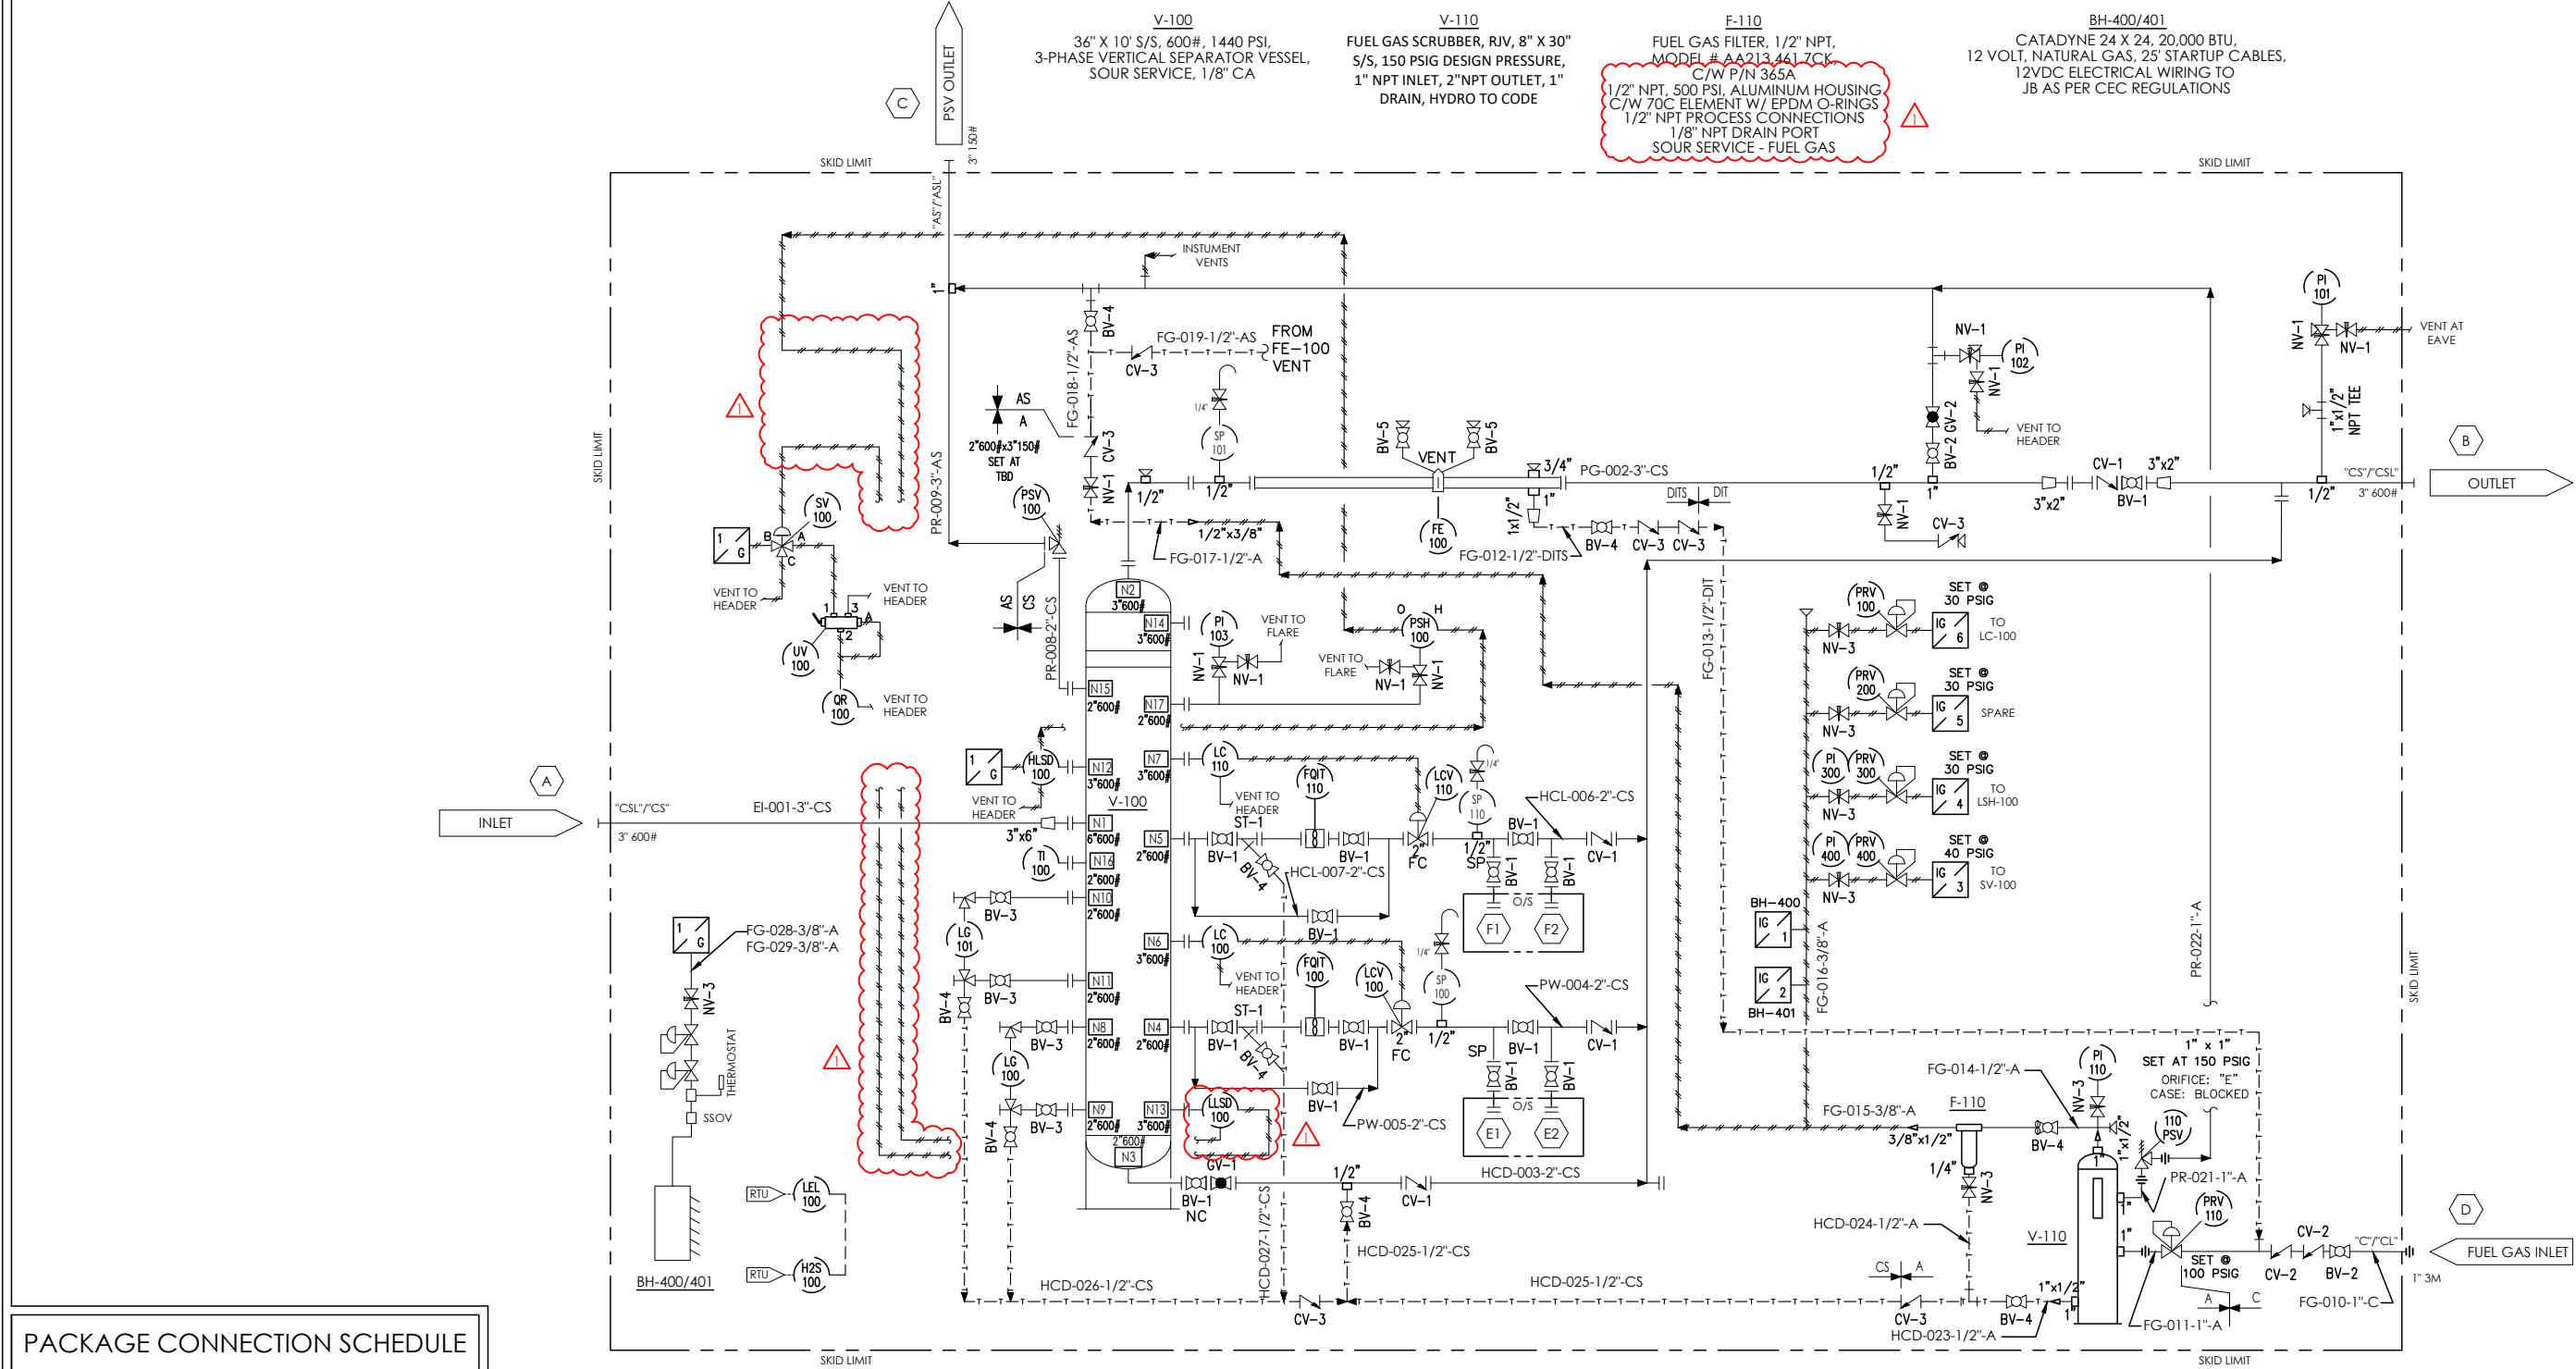

PACKAGE CONNECTION SCHEDULE

#	DESCRIPTION
A	INLET - 3" 600# RF
B	OUTLET - 3" 600# RF
C	PSV OUTLET - 3" 150# RF
D	FUEL GAS INLET - 1" NPT
E1/E2	PROVER TAPS - 2" 600 RF
F1/F2	PROVER TAPS - 2" 600 RF

1	02/28/2024	REVISED AS PER MUHAMMAD 02/13/2024 REDLINES	AG	MM	.
0	11/24/2023	ISSUED FOR CONSTRUCTION	MC	MM	.
B	10/19/2023	ADDED LINE NUMBERS - REISSUED FOR APPROVAL	MC	MM	MM
A	06/26/2023	ISSUED FOR APPROVAL	JMR	MC	MM
REV. No.	DATE	DESCRIPTION	CALC. NO.	BY	CHK'D APP'D

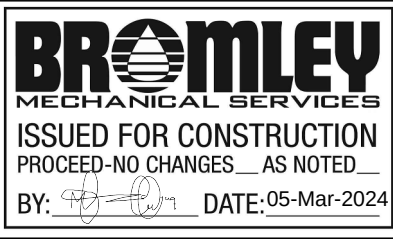

BROMLEY
MECHANICAL SERVICES
ISSUED FOR CONSTRUCTION
PROCEED-NO CHANGES AS NOTED
BY: [Signature] DATE: 05-Mar-2024

CLIENT:

STOCK



BROMLEY
MECHANICAL SERVICES
A DIVISION OF ARGOS SALES LP
925 23 Street SW, Medicine Hat, Alberta, Canada T1A 8R1
Ph: (403) 526-3142 Fax: (403) 526-1061
Toll Free (800) 215-9806

PROJECT:		36"OD X 10'-0" S/S X 1440 PSI STOCK 3PH SEPARATOR PACKAGE			
TITLE:		P&ID			
WO No.:	01943	LSD: .			
DRAWN BY:	J.REIMER	REV. No.:	1	SIZE:	
DATE: MM/DD/YY	06/26/2023	SCALE:	NTS	DWG No.:	01943-P&ID_SHT1
				B	

[illegible]

NOTES:

1. CLASS CS/AS/A THREADED PIPING TO BE SCH.160, SA106B. FITTINGS TO BE 3M, SA105N
2. CLASS CSL/ASL/AL THREADED PIPING TO BE SCH.160, SA333GR6. FITTINGS TO BE 3M, SA350LF2 CL.1.
3. CLASS A/AS/ASL THREADED PIPE AND PROCESS TUBING TO BE HYDROTESTED TO 2,945 kPag (427 PSIG)
4. CLASS CS/CSL THREADED PIPE AND PROCESS TUBING TO BE HYDROTESTED TO 7,654 kPag (2,220 PSIG)
5. TUBING & FITTINGS TO BE SWAGELOK. PROCESS TUBING TO BE 316 FULLY ANNEALED 0.049" WT. SENSING TUBING UNDER 1/2" TO BE 0.035" WT



CLIENT:



925 23 Street SW, Medicine Hat, Alberta, Canada T1A 8R
Ph: (403) 526-3142 Fax: (403) 526-1061
Toll Free (800) 215-9806

PROJECT:

36"OD X 10'-0" S/S X 1440 PSI
STOCK 3-P SOUR METERING PACKAGE

TITLE: P&ID

WO No.:	01943	LSD: .		
DRAWN BY:	J.REIMER	REV. No.:	1	SIZE:
DATE: MM/DD/YY	06/26/2023	SCALE:	NTS	DWG No.: 01943-P&ID_SHT2
				B